
<u>KET</u>	
FC	Floor to Ceiling
FFC	Floor to False Ceiling
F-C	Floor to Cill
С—Н	Cill to Head
CRO	Cill to Crown
SPR	Cill to Springer
USB	Underside of Beam
RAD	Radiator

DH Doorhead

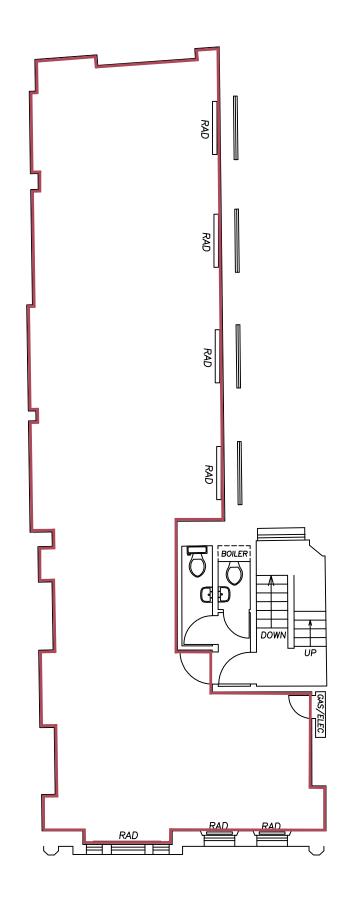



GRYPHON SURVEYS		Drawn L.J.R. Checked		D
Hanover House	26 EASTCASTLE STREET LONDON W1			С
78-82 High Street Brentwood, Essex CM14 4AP				В
Telephone: 01277-212794 Fax: 01277-214928	Title:	Scale 1:100@A3		A
e—mail: admin@gryphonsurveys.co.uk www.gryphonsurveys.co.uk	SECOND FLOOR PLAN	Date 08/07	Ref: 4	